


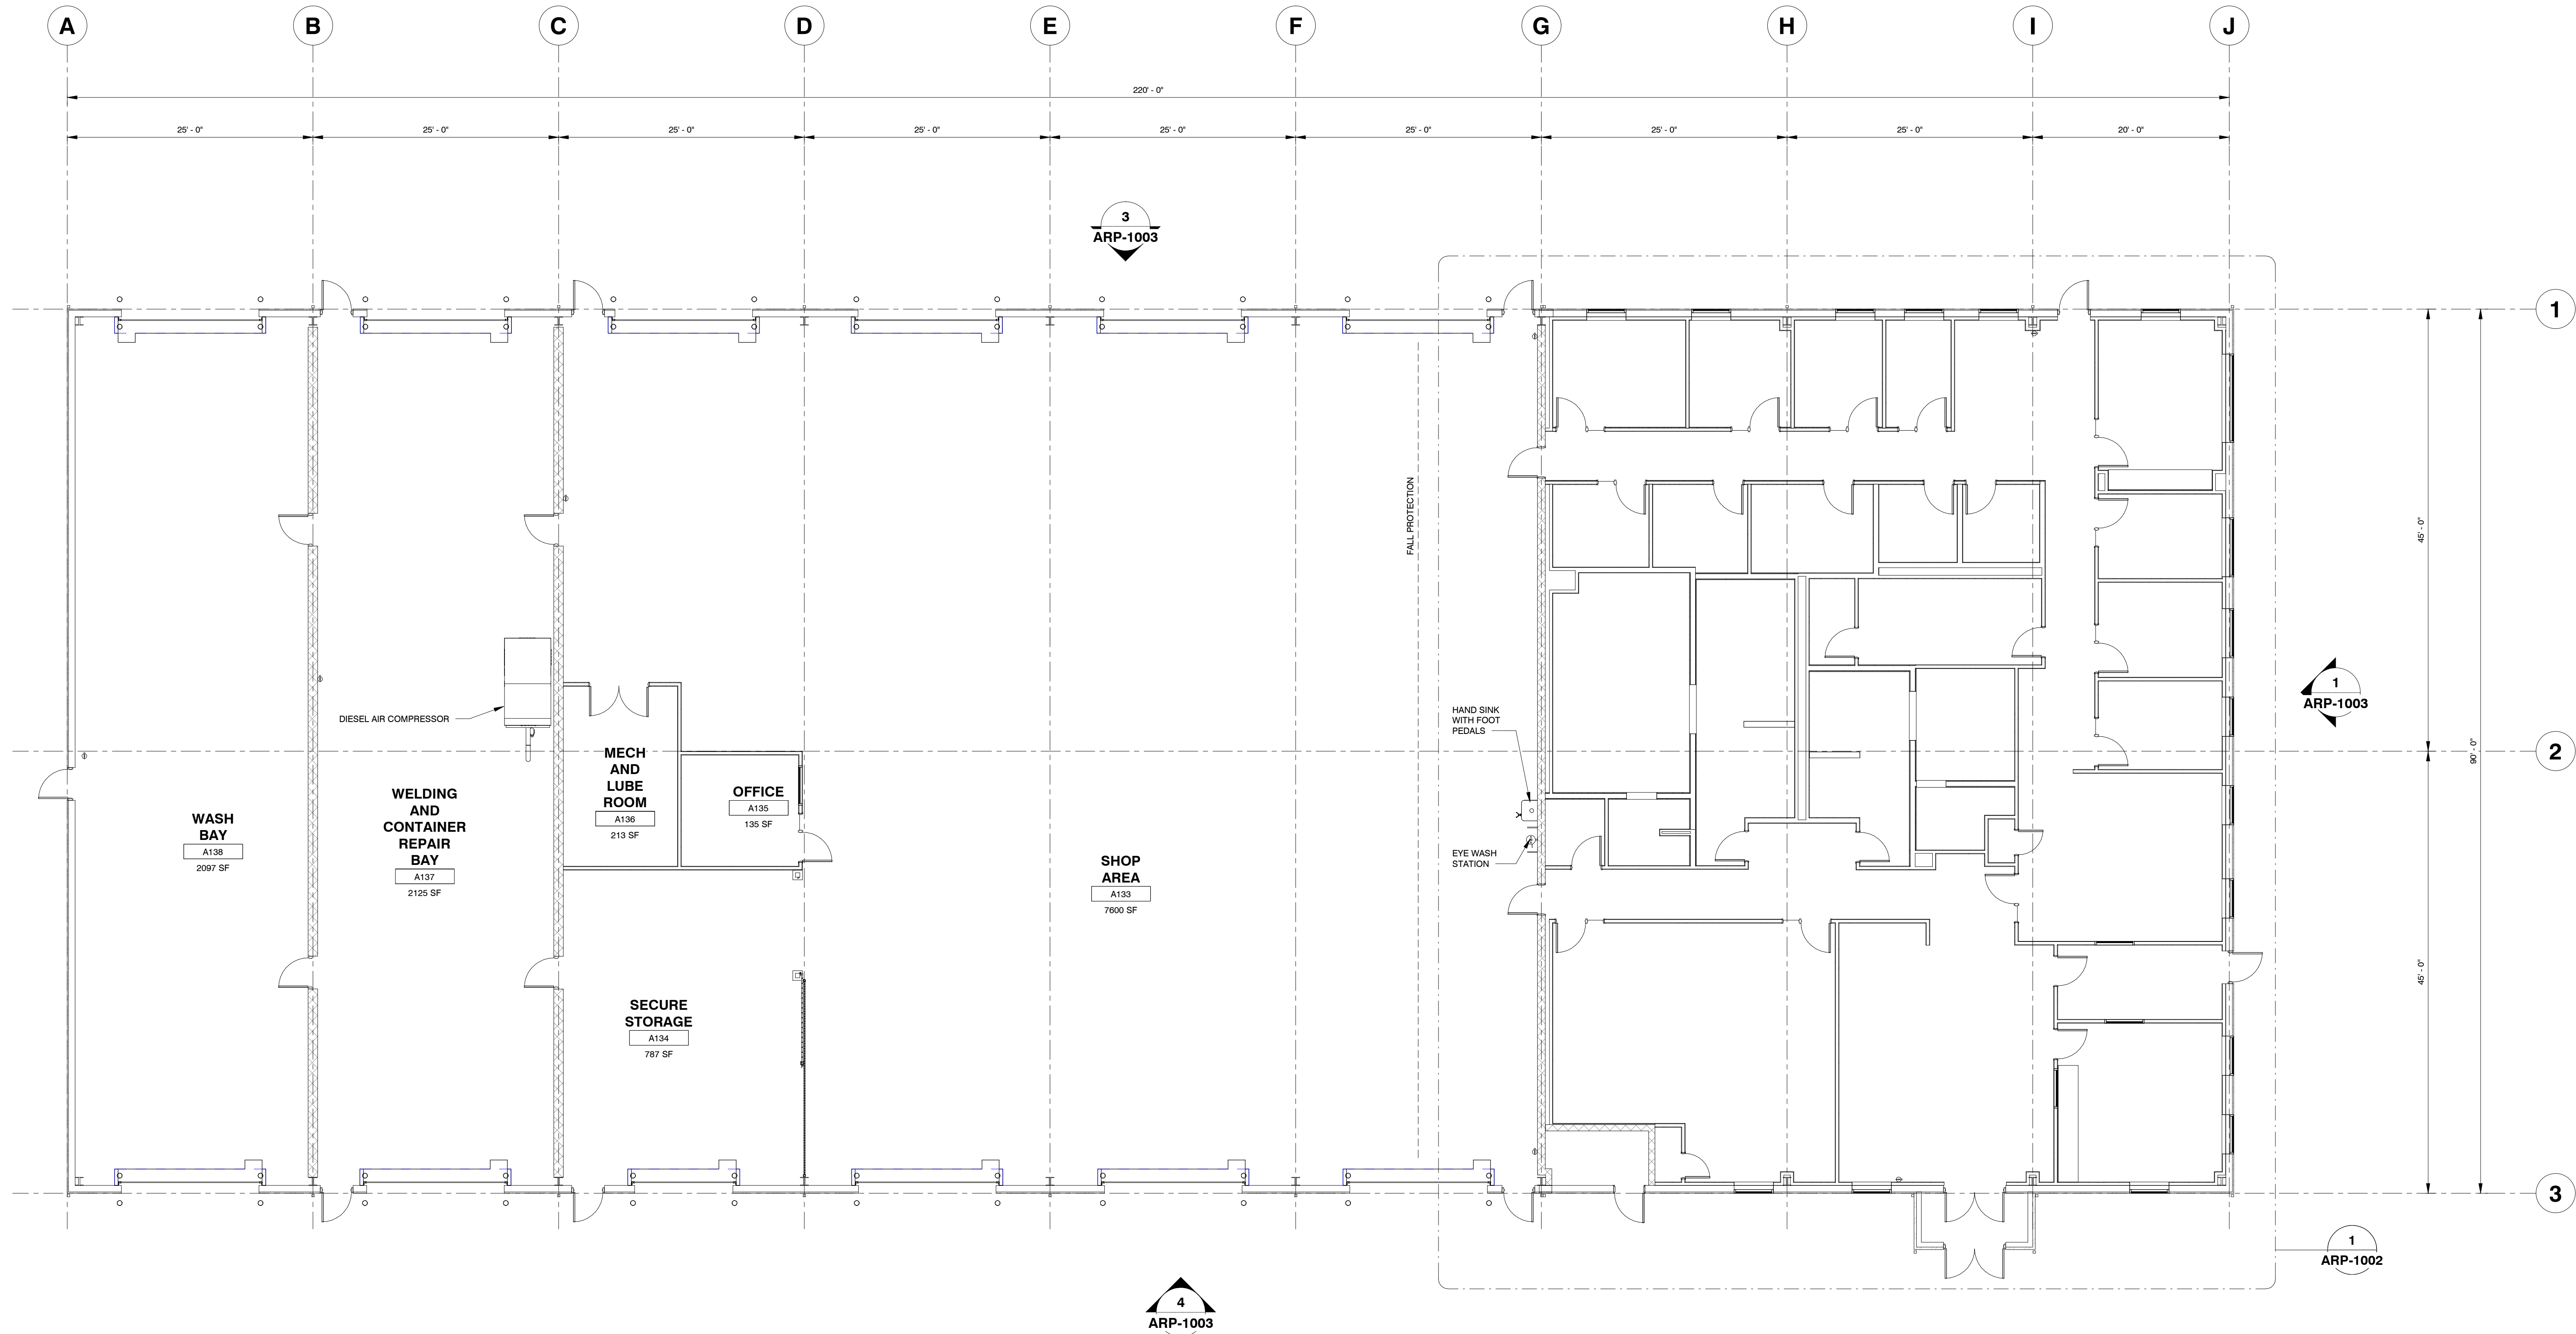

PLAN  
1/8" = 1'-0"

|                                                                                                                                                                                                                                                                                                                                                        |             |                                        |             |                               |  |                                                       |  |                        |  |              |  |
|--------------------------------------------------------------------------------------------------------------------------------------------------------------------------------------------------------------------------------------------------------------------------------------------------------------------------------------------------------|-------------|----------------------------------------|-------------|-------------------------------|--|-------------------------------------------------------|--|------------------------|--|--------------|--|
| ARCHITECTURAL<br>CASELLA FACILITY<br>ADMIN/SHOP BUILDING<br>FLOOR PLAN                                                                                                                                                                                                                                                                                 |             | D. RECTOR<br>S. MARITZER<br>R. SUSALLA |             | DATE:<br>OCT 2020<br>AS SHOWN |  | DRAWN BY:<br>S. MARITZER<br>CHECKED BY:<br>R. SUSALLA |  | PROJECT NO:<br>382,793 |  | APPROVED BY: |  |
| CASELLA WASTE SYSTEMS, INC.<br>FORT EDWARD HAULING DIVISION FACILITY<br>NEW DEVELOPMENT<br>TOWN OF MOREAU, NY                                                                                                                                                                                                                                          |             |                                        |             |                               |  |                                                       |  |                        |  |              |  |
| <br>Civil & Environmental<br>Consultants, Inc.                                                                                                                                                                                                                     |             |                                        |             |                               |  |                                                       |  |                        |  |              |  |
| 700 Cherrington Parkway<br>Moon Township, Pa 15108<br>412-429-2324 • 800-365-2324<br>www.cecinc.com                                                                                                                                                                                                                                                    |             |                                        |             |                               |  |                                                       |  |                        |  |              |  |
| REVISION RECORD                                                                                                                                                                                                                                                                                                                                        |             |                                        |             |                               |  |                                                       |  |                        |  |              |  |
| NO.                                                                                                                                                                                                                                                                                                                                                    | DATE        | BY                                     | CHK         | DESCRIPTION                   |  |                                                       |  |                        |  |              |  |
| 1                                                                                                                                                                                                                                                                                                                                                      | 07 OCT 2020 | D. RECTOR                              | S. MARITZER | ISSUED FOR REVIEW             |  |                                                       |  |                        |  |              |  |
| ENGINEERING, SURVEYING AND LANDSCAPE ARCHITECTURE IN THE STATE OF NORTH CAROLINA WILL BE PROVIDED BY CEC SURVEYING AND LANDSCAPE ARCHITECTS OF INC. ALL SERVICES IN ALBERTA WEDD WILL BE PROVIDED BY CEC ENGINEERS & CONSULTANTS, LLC. LANDSCAPE ARCHITECTURE SERVICES IN THE STATE OF OHIO WILL BE PROVIDED BY CEC LANDSCAPE ARCHITECTS OF OHIO, LLC. |             |                                        |             |                               |  |                                                       |  |                        |  |              |  |

ARP-1001

SHEET 1 OF 1



ARCHITECTURAL  
CASELLA FACILITY  
ADMIN/SHOP BUILDING  
ENLARGED FLOOR PLAN - ADMIN

DRAWING NO.:  
**ARP-1002**

SHEET 1 OF 1

DATE: OCT 2020  
DWG SCALE: AS SHOWN  
PROJECT NO.: 3802-783  
APPROVED BY: R. SUSALLA

D. RECTOR  
S. MARITZER

CASELLA WASTE SYSTEMS, INC.  
FORT EDWARD HAULING DIVISION FACILITY  
NEW DEVELOPMENT  
TOWN OF MOREAU, NY


Civil & Environmental  
Consultants, Inc.

700 Cherrington Parkway  
Moon Township, Pa 15108  
412-429-2324 • 800-365-2324  
www.cecinc.com

REVISION RECORD

| NO. | DATE        | DRAWN     | CHECK       | DESCRIPTION       |
|-----|-------------|-----------|-------------|-------------------|
| A   | 07 OCT 2006 | D. RECTOR | S. MARITZER | ISSUED FOR REVIEW |

ENGINEERING, SURVEYING AND LANDSCAPE ARCHITECTURE IN THE STATE OF NORTH CAROLINA WILL BE PROVIDED BY CEC SURVEYING AND LANDSCAPE ARCHITECTS OF INC. ALL SERVICES AND MATERIALS WILL BE PROVIDED BY CEC ENGINEERS & CONSULTANTS, LLC. LANDSCAPE ARCHITECTURE SERVICES IN THE STATE OF OHIO WILL BE PROVIDED BY

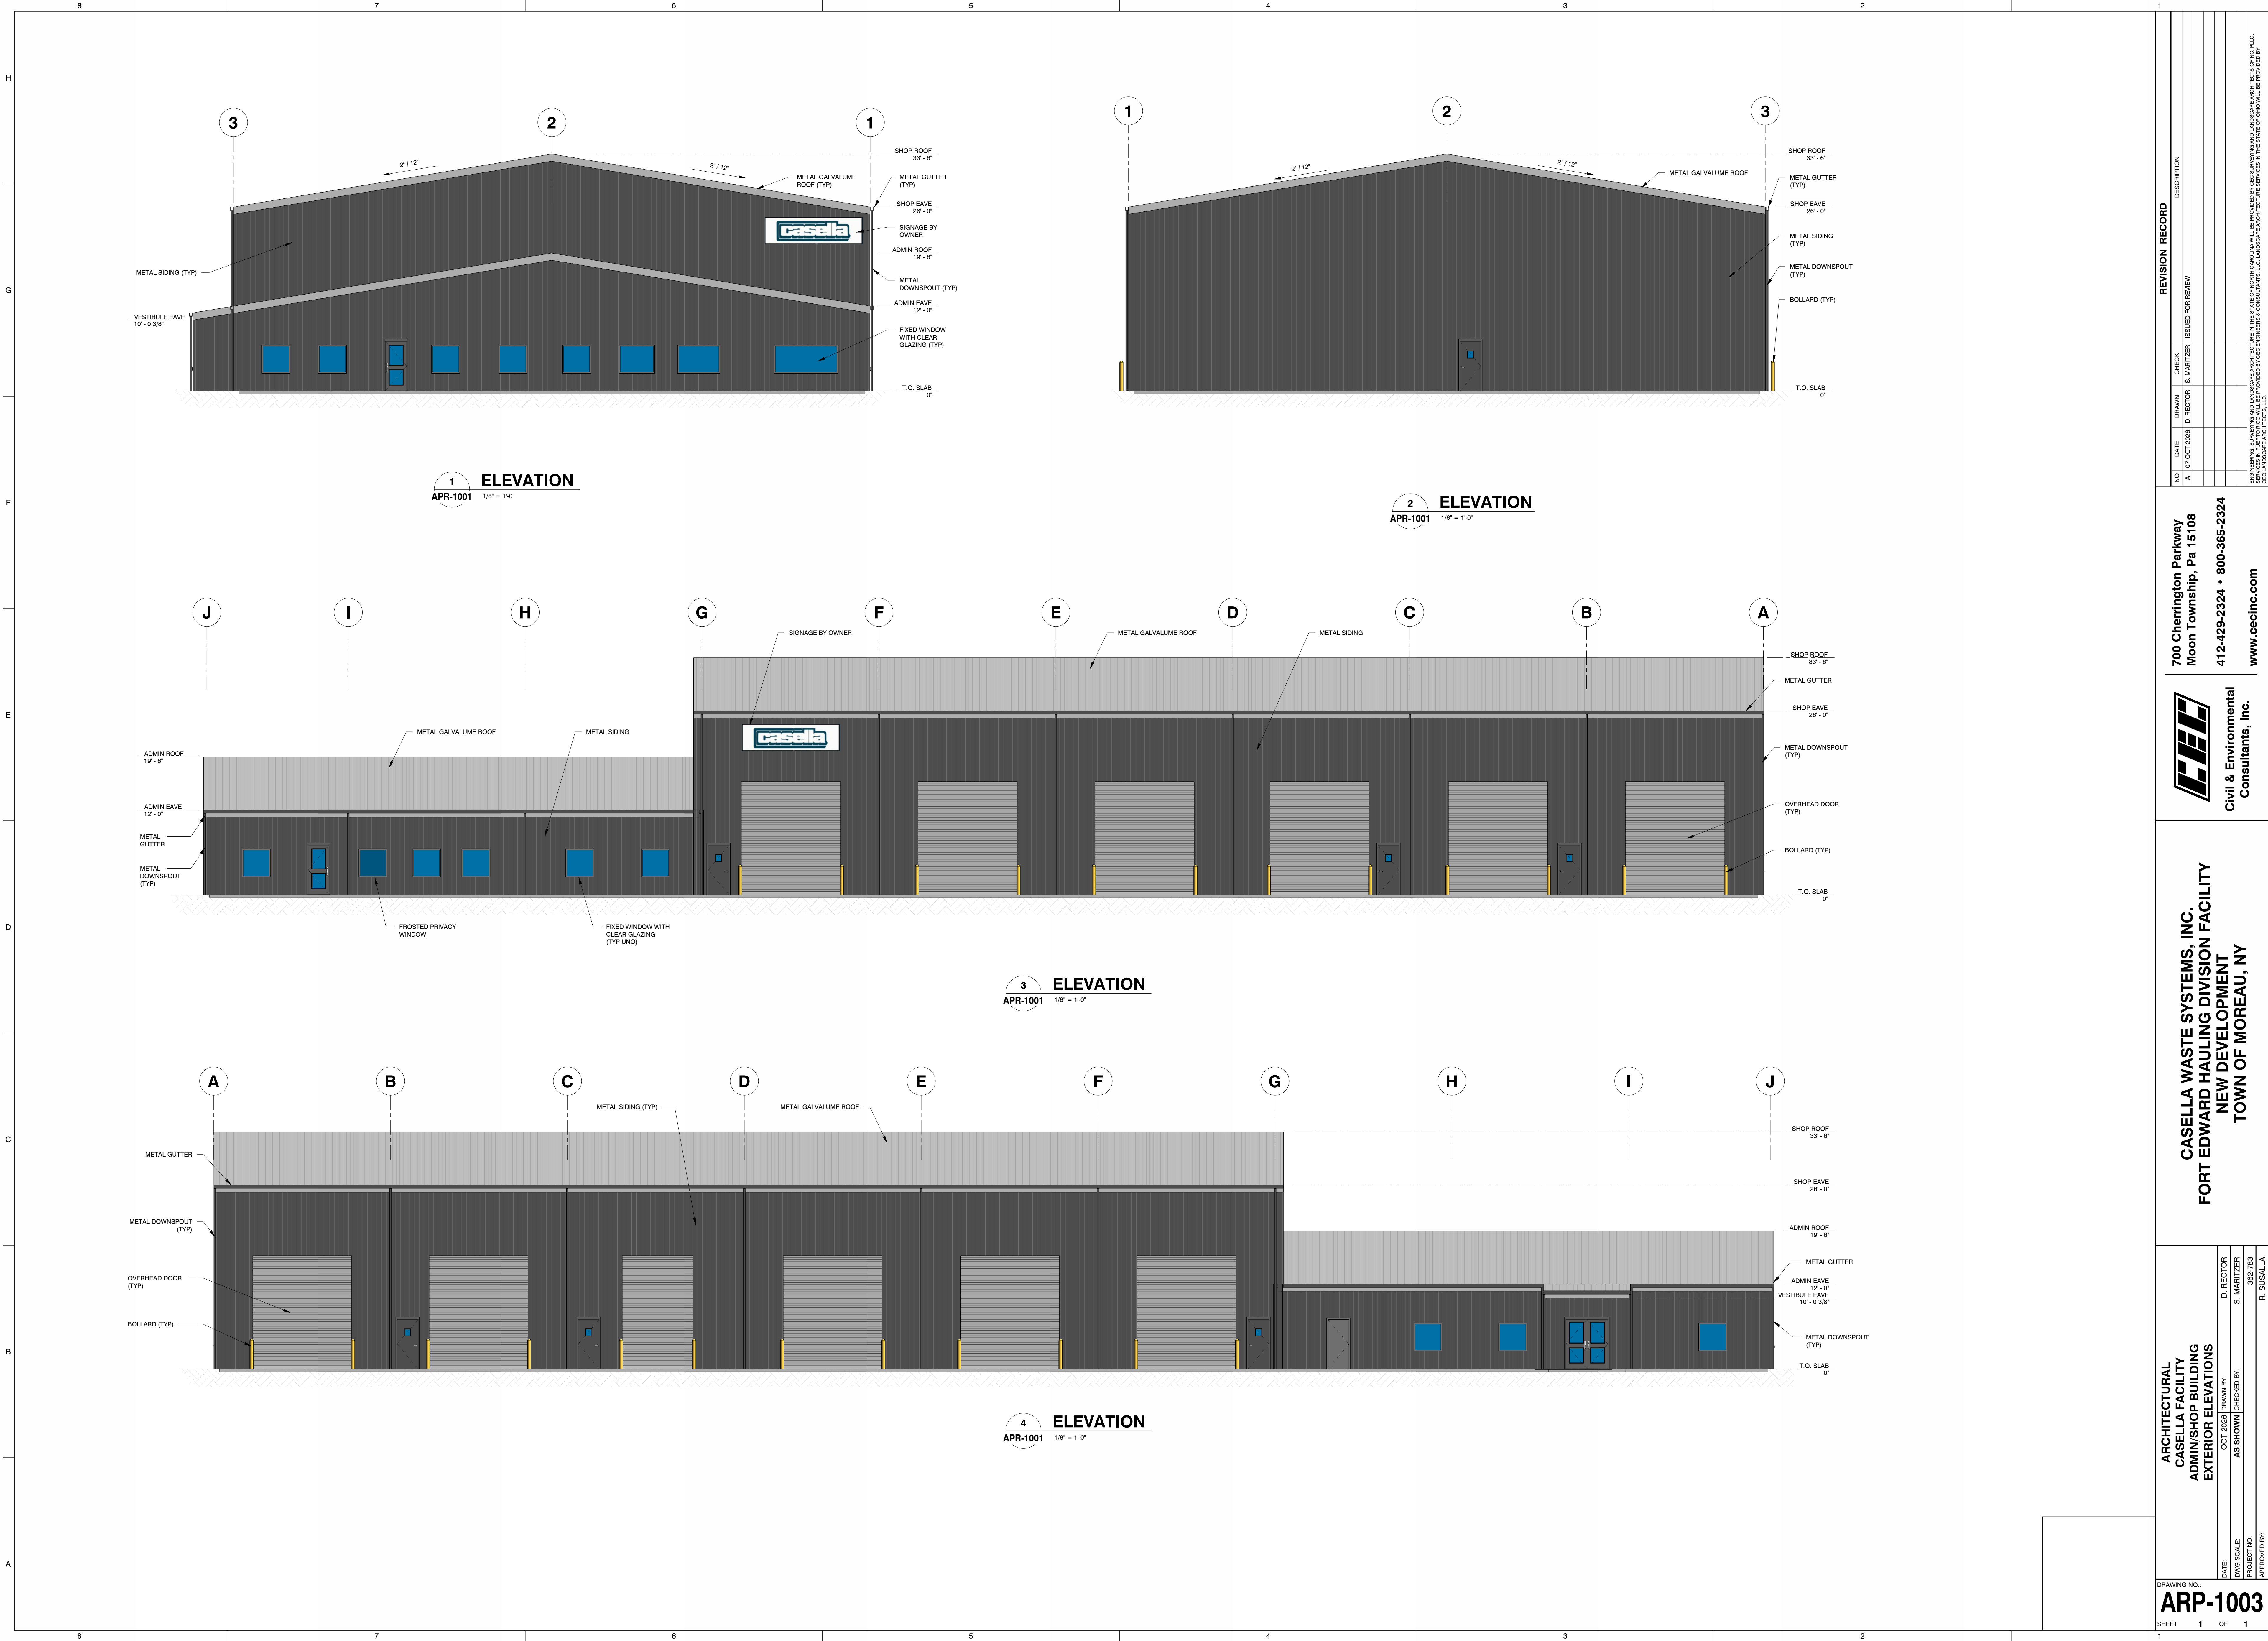


| REVISION RECORD |             |           |             |                   | DESCRIPTION |
|-----------------|-------------|-----------|-------------|-------------------|-------------|
| NO.             | DATE        | DRAWN     | CHECKED     | ISSUED FOR REVIEW |             |
| A               | 07 OCT 2024 | D. RECTOR | S. MARITZER |                   |             |

700 Cherrington Parkway  
Moon Township, Pa 15108  
412-429-2324 • 800-365-2324  
www.cecinc.com



CASELLA WASTE SYSTEMS, INC.  
FORT EDWARD HAULING DIVISION FACILITY  
NEW DEVELOPMENT  
TOWN OF MOREAU, NY

|                                                                                 |              |            |
|---------------------------------------------------------------------------------|--------------|------------|
| ARCHITECTURAL<br>CASELLA FACILITY<br>ADMIN/SHOP BUILDING<br>EXTERIOR ELEVATIONS | DRAWING NO.  | D. RECTOR  |
|                                                                                 | DATE:        | OCT 2024   |
|                                                                                 | PROJECT NO.  | 382,783    |
|                                                                                 | APPROVED BY: | R. SUSALLA |

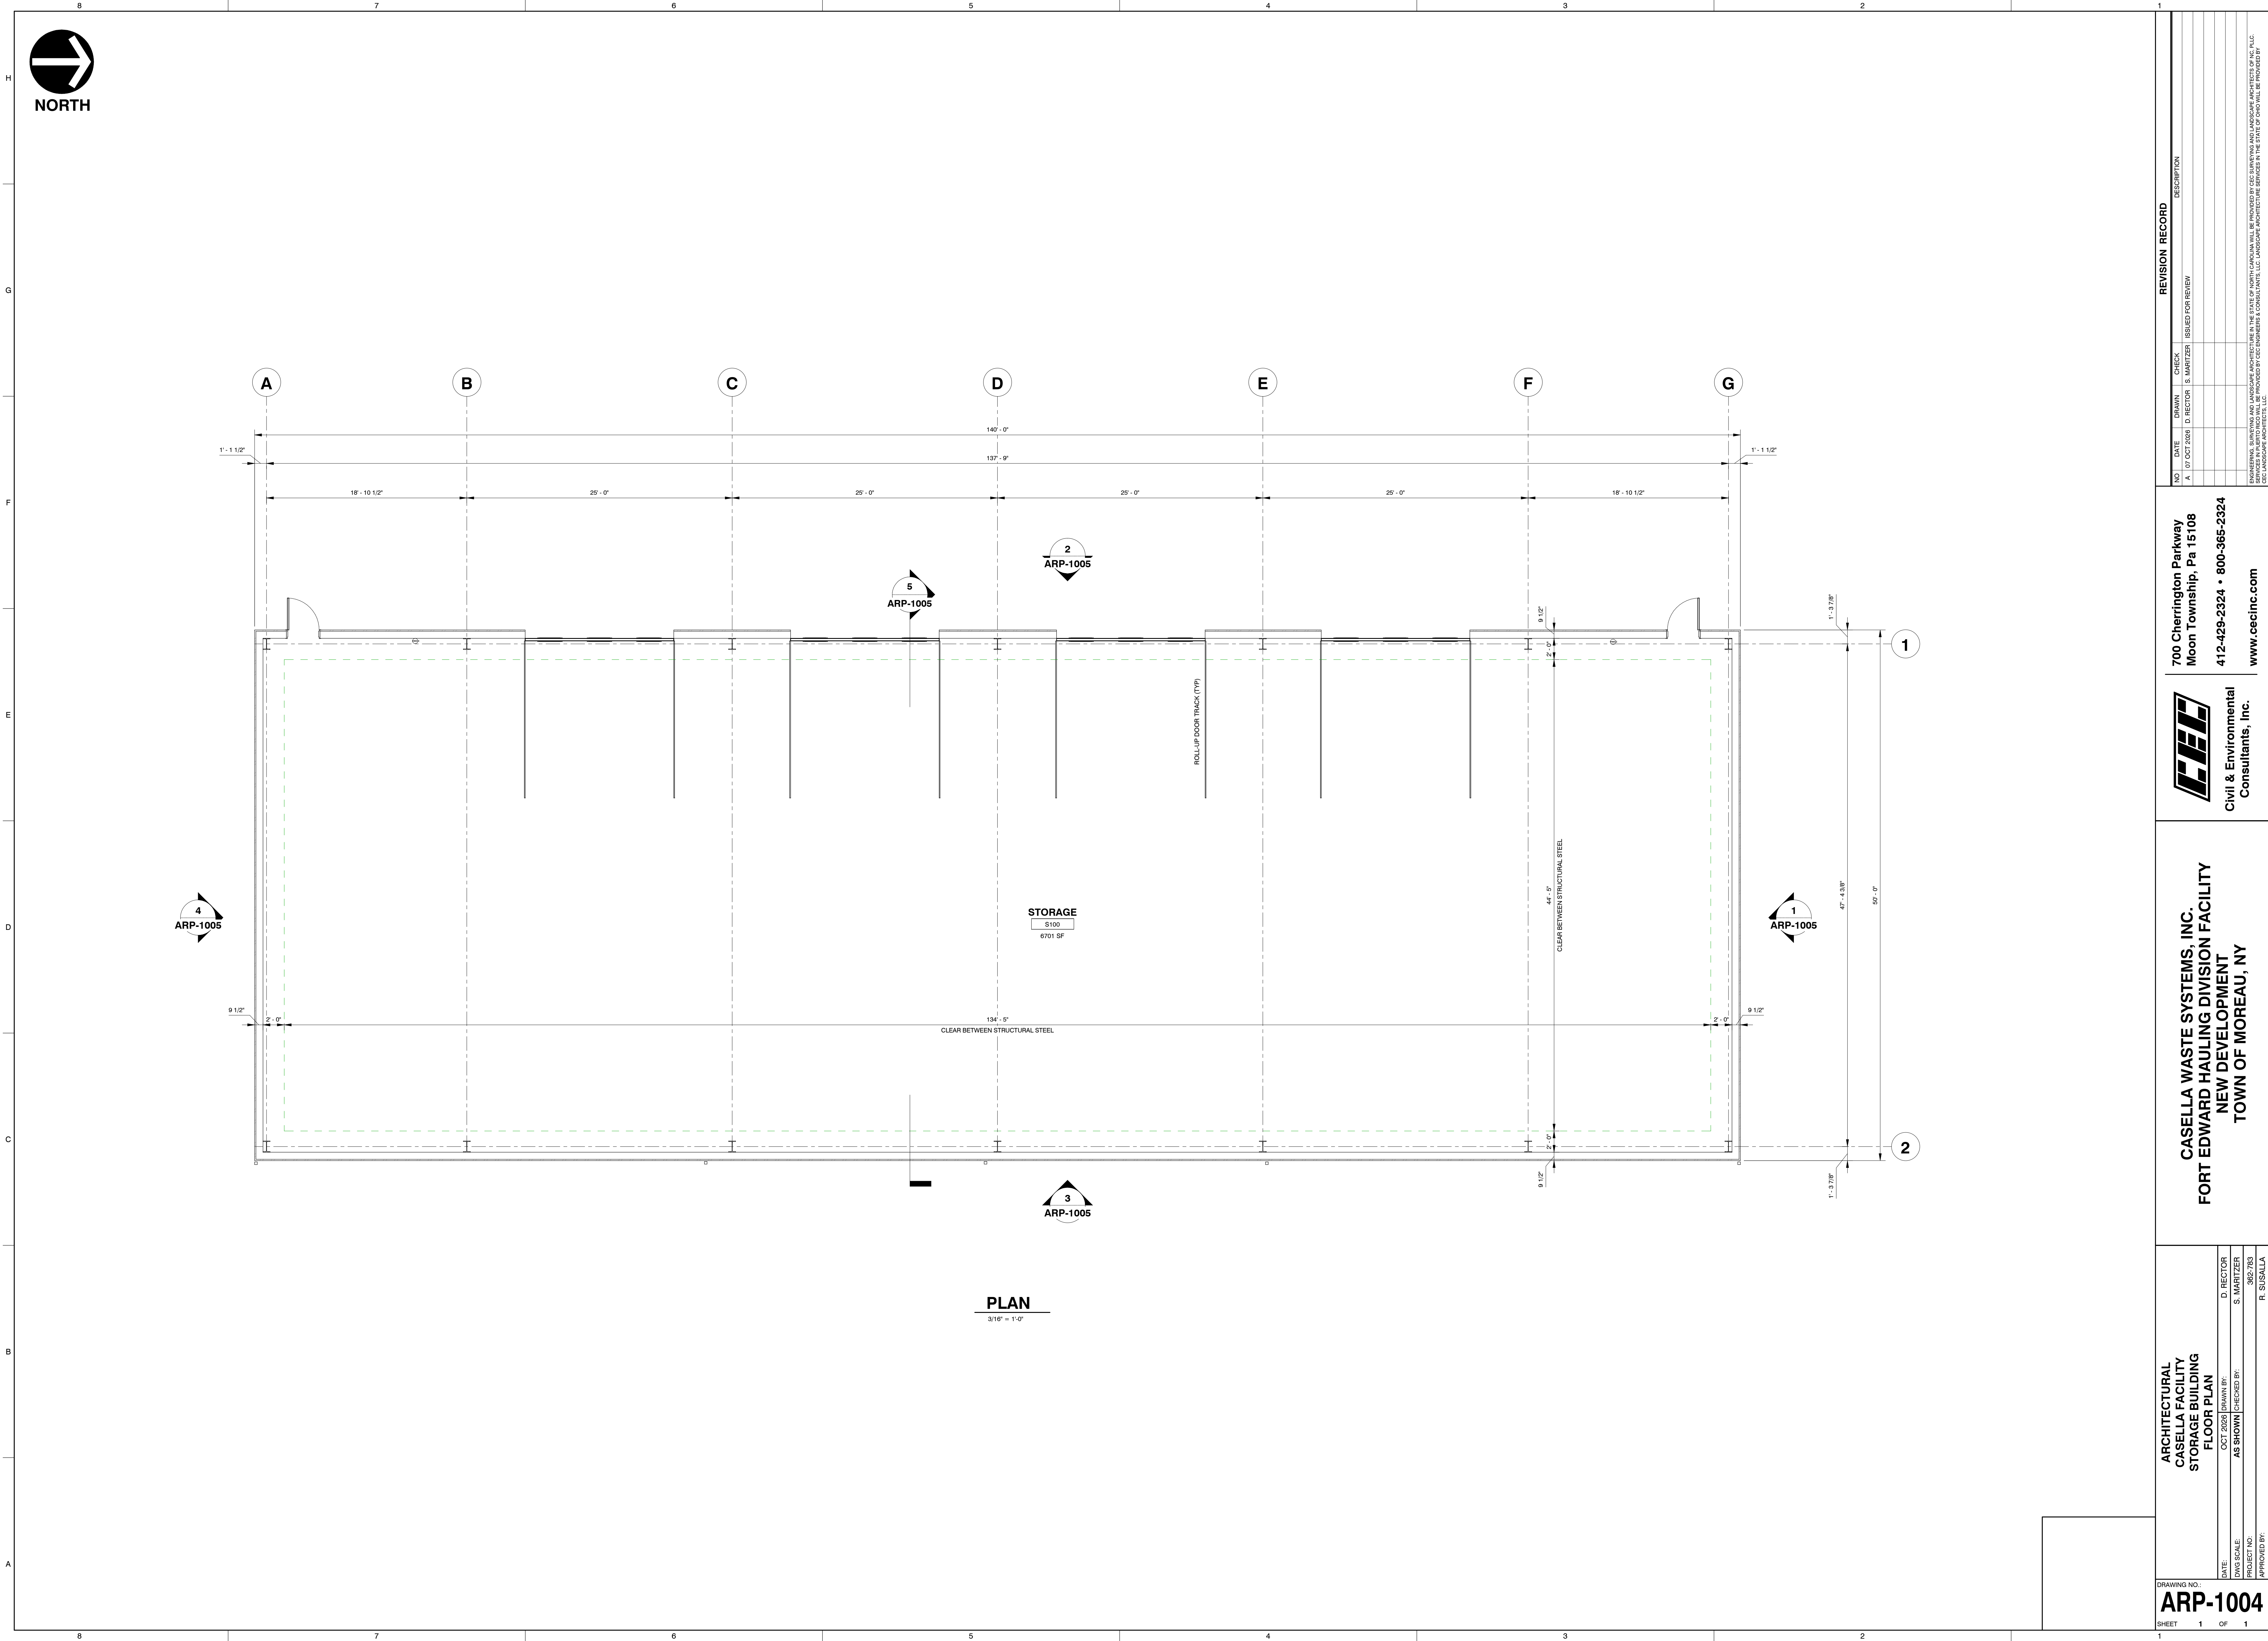

ARCHITECTURAL  
CASELLA FACILITY  
STORAGE BUILDING  
FLOOR PLAN

DRAWING NO.  
**ARP-1004**

SHEET 1 OF 1

DATE:  
OCT 2020

DWG SCALE:  
AS SHOWN

PROJECT NO.  
3802783

APPROVED BY:  
R. SUSALLA

D. DIRECTOR  
S. MARITZER

CASELLA WASTE SYSTEMS, INC.  
FORT EDWARD HAULING DIVISION FACILITY  
NEW DEVELOPMENT  
TOWN OF MOREAU, NY


  
Civil & Environmental  
Consultants, Inc.

700 Cherrington Parkway  
Moon Township, Pa 15108  
412-429-2324 • 800-365-2324  
www.cecinc.com

REVISION RECORD


| NO. | DATE        | DRAWN       | CHECK       | DESCRIPTION       |
|-----|-------------|-------------|-------------|-------------------|
| A   | 07 OCT 2020 | D. DIRECTOR | S. MARITZER | ISSUED FOR REVIEW |
|     |             |             |             |                   |
|     |             |             |             |                   |
|     |             |             |             |                   |
|     |             |             |             |                   |

ENGINEERING, SURVEYING AND LANDSCAPE ARCHITECTURE IN THE STATE OF NORTH CAROLINA WILL BE PROVIDED BY CEC SURVEYING AND LANDSCAPE ARCHITECTS OF INC. ALL SERVICES IN ALBERTA REGIONS WILL BE PROVIDED BY CEC ENGINEERS & CONSULTANTS, L.L.C. LANDSCAPE ARCHITECTURE SERVICES IN THE STATE OF OHIO WILL BE PROVIDED BY CEC ENGINEERS & CONSULTANTS, L.L.C.

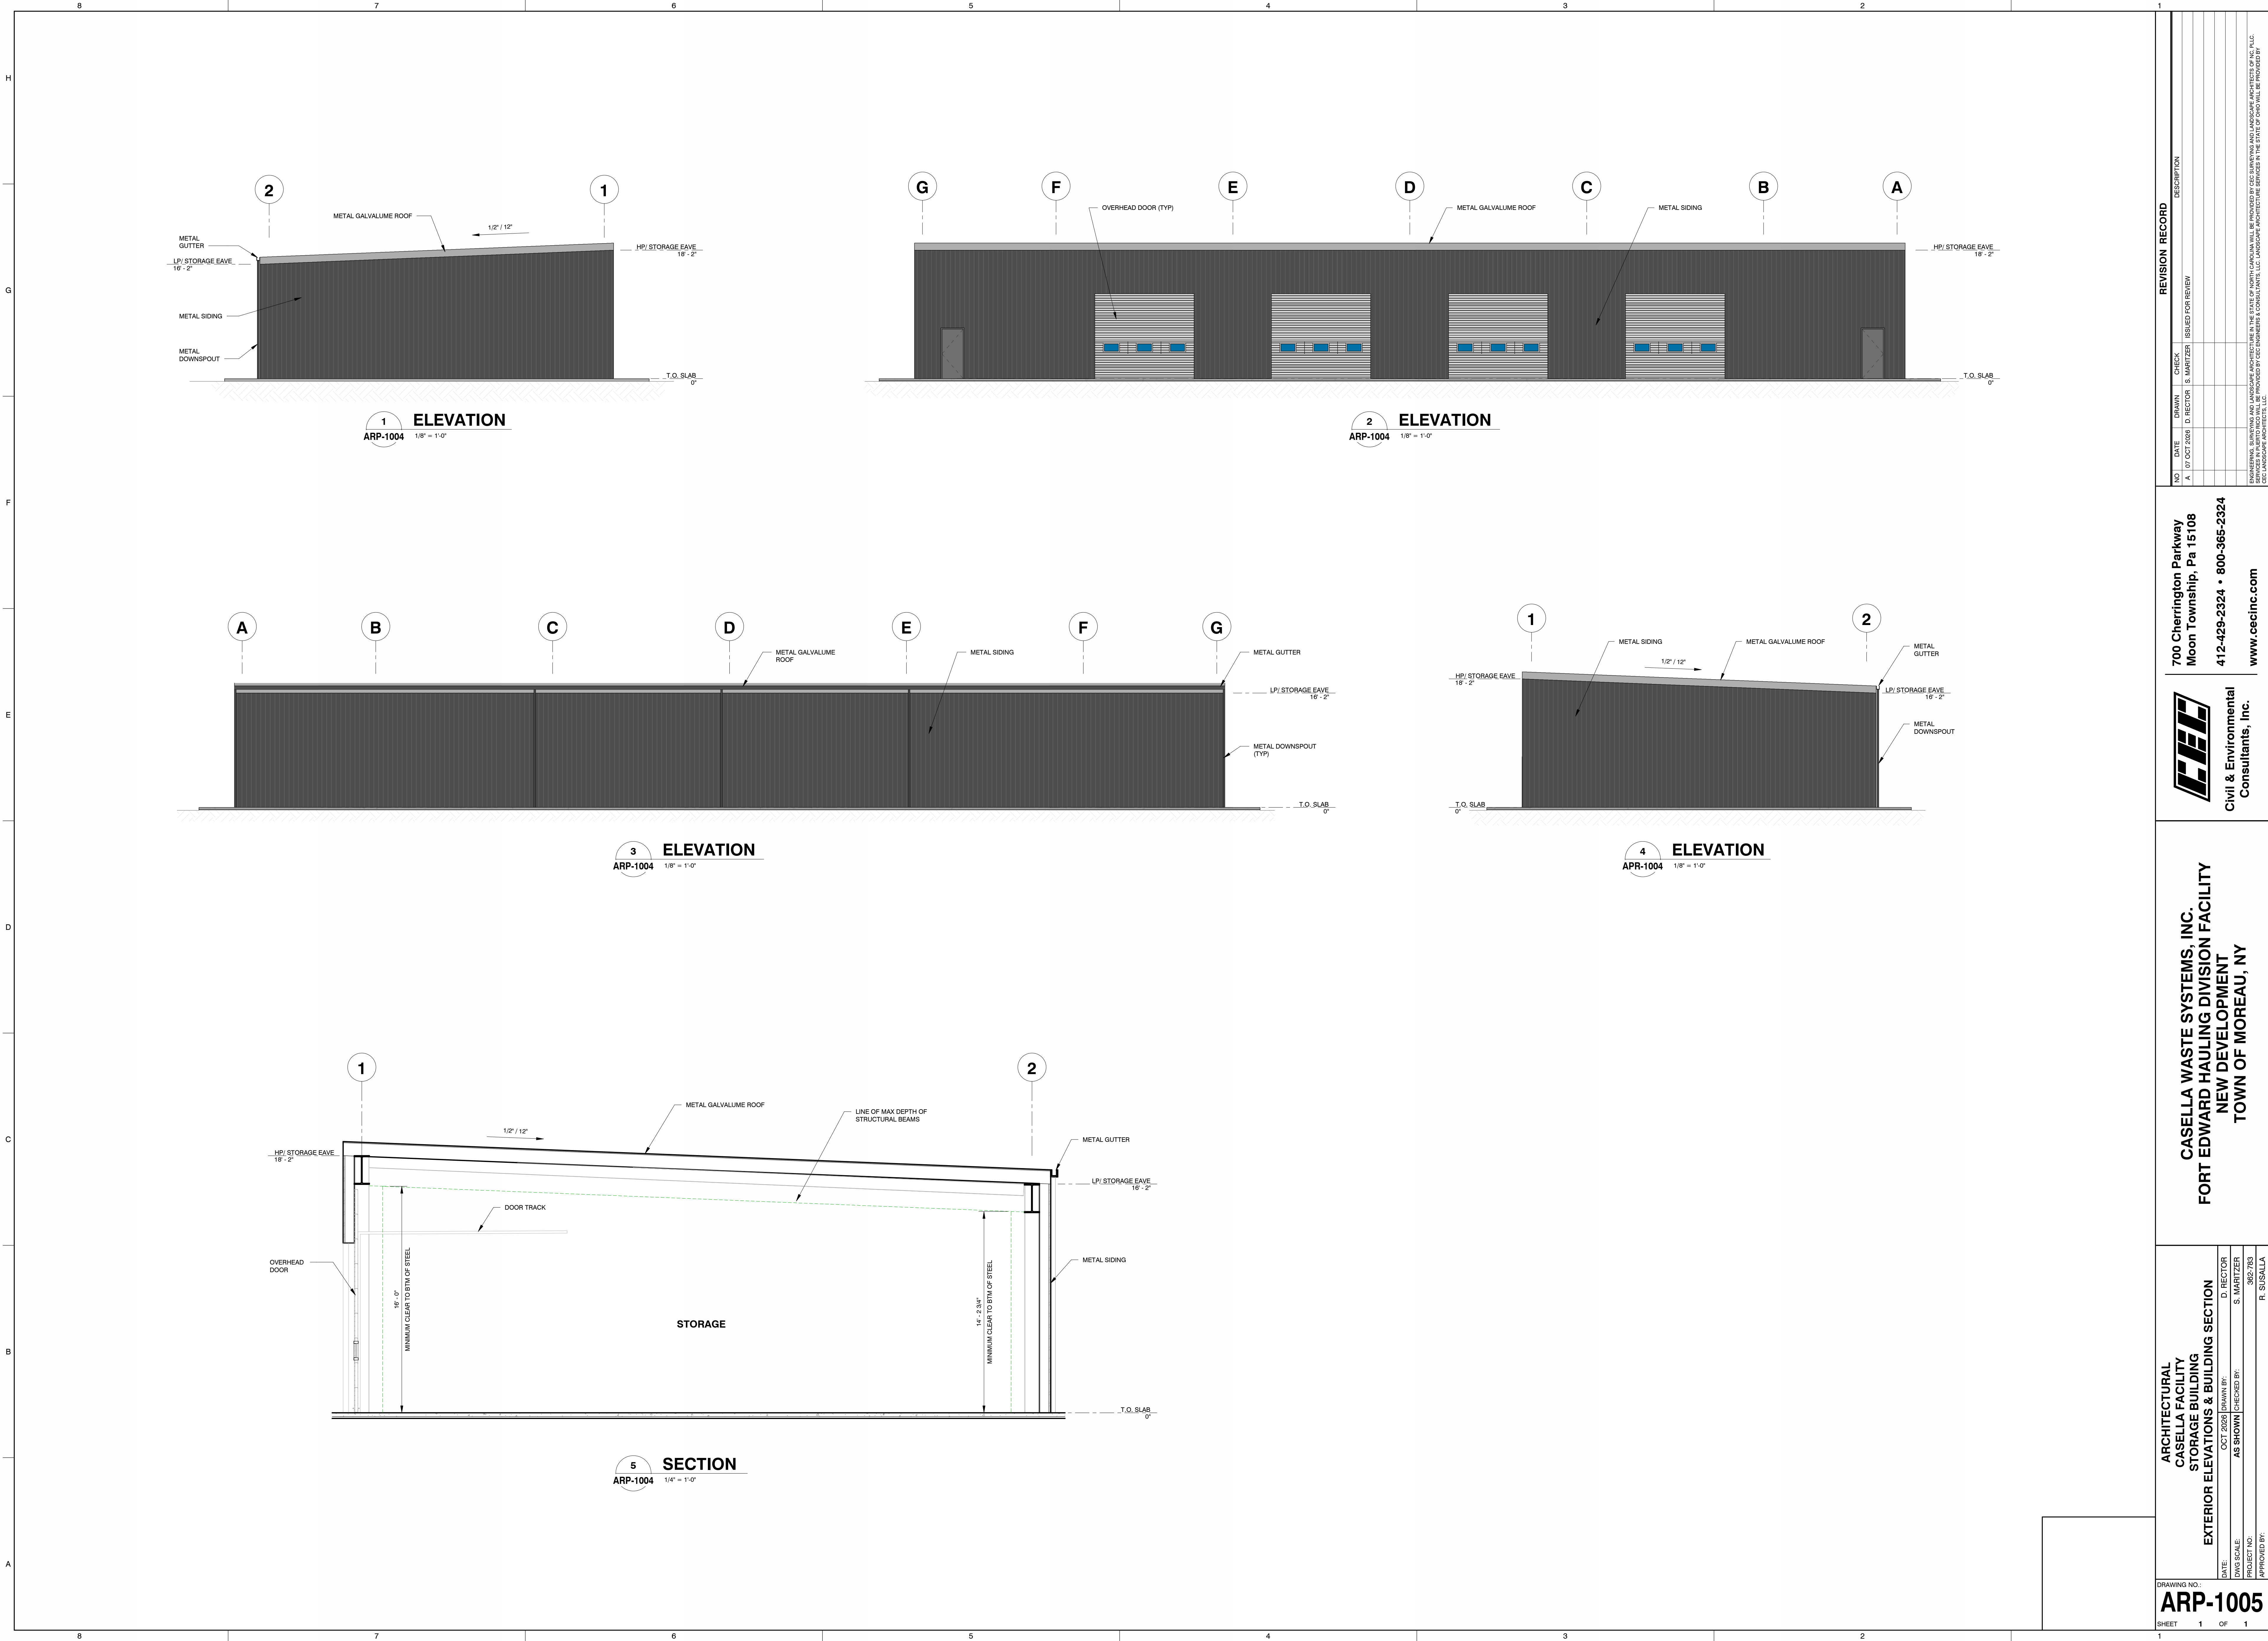

| REVISION RECORD |             |           |             |                   | DESCRIPTION |
|-----------------|-------------|-----------|-------------|-------------------|-------------|
| NO.             | DATE        | DRAWN     | CHECK       | ISSUED FOR REVIEW |             |
| A               | 07 OCT 2004 | D. RECTOR | S. MARITZER |                   |             |

700 Cherrington Parkway  
Moon Township, Pa 15108  
412-429-2324 • 800-365-2324  
www.ccecinc.com

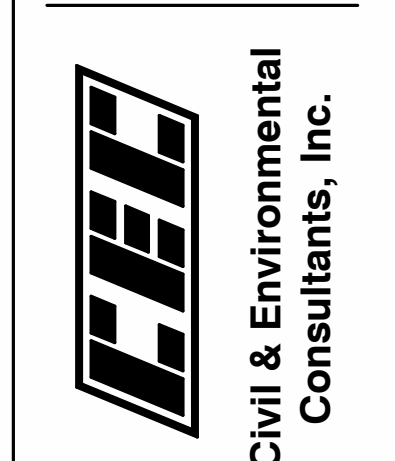

CASELLA WASTE SYSTEMS, INC.  
FORT EDWARD HAULING DIVISION FACILITY  
NEW DEVELOPMENT  
TOWN OF MOREAU, NY

|                                                                                                 |                                       |                                                 |           |
|-------------------------------------------------------------------------------------------------|---------------------------------------|-------------------------------------------------|-----------|
| ARCHITECTURAL<br>CASELLA FACILITY<br>STORAGE BUILDING<br>EXTERIOR ELEVATIONS & BUILDING SECTION | DATE: OCT 2020<br>DWG SCALE: AS SHOWN | DRAWN BY: S. MARITZER<br>CHECKED BY: R. SUSALLA | D. RECTOR |
|-------------------------------------------------------------------------------------------------|---------------------------------------|-------------------------------------------------|-----------|

DRAWING NO.:  
**ARP-1005**  
SHEET 1 OF 1

